

A-1 cover sheet A-2 elevations A-3 elevations

drawing index

A-3 elevations
A-4 foundation / basement floor plan
A-5 main / upper floor plan
A-6 roof plan
A-7 section/details
E-1 electrical plan

code summary & design criteria

2019 residential code of ohio ROC)
2018 international enegy conservation code (IECC)
2017 national electric code (NED)

Design Snow Load: section 301 design criteria figure 301.2(5) ground snow loads roof snow load = 20 psf

Design Wind Load: table 301.2(2) component and cladding loads for a building with a mean roof height of 30 feet located in exposure b 90 mph (3 second gust)

Square Foot (Finished/Living)	
Basement	655
Main Floor	883
Upper Floor	1050
Total	259 ⁻
Concrete	
Basement	81(
Garage	289
Entry Covered Porch	(
Rear Covered Porch	(

general notes

the use of these documents is restricted to the ordinal sirte for which they where prepared, reuse or reproduction of the documents (in whole or in part), for any other purpose is prohibited. Streamline Designs, and Jonah Bok retains all rights of ownership for these documents.

do not scale drawings, written dimensions govern.

if a discrepency or conflict between code requirements,

details, specifications, engineering data, manufactures's recommendations, or owner provided information becomes know to the contractor, he or she shall promptly report to the conflict or discreprepency in writing to the architect or owner's representative for clarification and corrected action, in addition, any work installed in conflict with requirements identified herein. without proper notification shall be corrected by the contractor at this or her expense, and at no cost to the architect, engineer, occupant, or building owner.

all exterior dimensions are from face of masonry to face of masonry, or face of sheathing unless otherwise noted. verify all dimensions prior to beginning work.

all interior dimensions are from the face of rough framing to face of rough framing unless otherwise noted. verify all dimensions prior to beginning work.

sub-contractor shall determine erection procedure and sequencing and provide whatever bracing that may be required to complete the work.

verify all rough openings with manufacturer prior to framing.

each sub-contractor shall obtain and pay for required permits and schedule at inspections and coordinate all trades.

the contractor and sub-contractors shall be solely responsible for complying with all federal, state and local safety requirements together with exercising precautions at all times for the protection of all persons including employees and property. it is the sole responsibility of the contractor and subcontractors to initiate, maintain and supervise all safety requirements, precautions and programs in connection with the

draftstopping shall be provided in all attic areas exceeding 3,000 sq. ft. in area

firestopping shall be installed in all concealed spaces of stud walls and partitions including furred or studded off spaces of masonry or concrete walls, and at the ceiling and floor or roof levels. firestopping shall be installed at the interconnections between vertical and horizontal spaced such as occurring at soffits over cabinets, drop ceilings, cove ceiling and etc.

symbols and abbreviations used on these drawings are considered to be construction standards. if the contractor has questions regarding abbreviations or symbols as to their exact meaing, the designer shall be notified at once for clarification.

		•
existing floor joist/ceiling joist/rafter direction	cantilever floors	half wall
loor joist direction	other floor building lines	face brick
eiling joist direction	roof line	walls above
after direction	elevation lines	
por truss direction	hidden line & post footing	plumbing fixtures above
pof truss girder	regular object line	c.m.u. foundation wall
nultiple joist or lvl	center line	contrasting foundation wall
eel beam	main floor walls	poured foundation wall
ooter	upper floor walls	living room
oset rod and shelf	basement floor walls	room name

abb	reviation lege	nd					
a.f.f. a.c.t. alum. appro bd.	above finish floor acoustical ceiling tile aluminum x.approximate board	elev. eq. ex. exp. jt. fin.	elevation equal existing expansion joint finish	max. mech. mtl. min. mldg	maximum mechanical metal minimum .moulding	sht. no sect. stl. fr	schedule sheet number section steel frame structural
b.o. blk'g bm. c.t. clg.	bottom of blocking beam ceramic tile ceiling	flr. g.b. gl. gyp. bo h.m.	floor glass block glass d gypsum board hollow metal	mtd. mfgr. n.i.c. n.t.s.	mounted manufacturer not in contract not to scale	s.g. susp. o sim. t. t.o.	supply grille clg. suspended ceiling similar tread top of
cl. c.j. clr. cmu col.	center line control joint clear dimension concrete masonry unit column	h.p. ht. hr. i.d. insul.	high point height hour inside dimension insulation	o.c. o.d. opn'g plas. plam.	on center outside dimension opening plaster plastic laminate	typ. u.n.o. v.i.f. vin.	typical unless noted otherwise verify in field vinyl
conc. contr. cpt. d.s. dbl.	concrete contractor carpet down spout double	jst. brg l.p. m.o. mas. mat'l.	. joist bearing low point masonry opening masonry material	ptd. plumb. r. r.d. r.o.	painted plumbing riser roof drain rough opening	vnr. v.b. w.w.f. w/ wd.	veneer vapor barrier welded wire fabric with wood
dtl. dn. dwg (s ea. elec.	detail down)drawings each electrical			ref. reinf. r.g. rfg.	refer to reinforced return grille roofing	w.p. win.	work point window



OHIO UTILITIES PROTECTION SERVICE

aseline structural	criteria (& design	in formation	
averine ou avair ur	of itol in	ส แกกเลิน	IIIIVI IIIUUVII	

erafolisour santi data Anio salandare sono ormous (de oso	E = 1,600,000 psi Fb = 1400 psi Fv = 105 psi	
n jednosta dijegoja nab		

Framing Lumber (Minimum):

symbol legend

cross section

stair direction

elevation heights

door size (3'-0")

sloped ceiling direction

point load above, continues load

point load above, transfered load to there bearing

Microlam (LVL) E = 1,900,000 psiFb = 2600 psiFv = 285 psi

Parallam (PSL): E = 2,000,000 psiFb = 2900 psiFv = 290 psi

kitchen cabinet and cased openings

Steel: ASTM A-36 E = 29,000,000 psiFb = 22 ksiFv = 14.5 ksi

Wind Speed (design) 90 MPH, ASD / 115 MPH ULT exposer B

Concrete: Interior = 3000 psi Exterior = 4000 psi (air)

Soil Bearing Capacity (Min.): 2000 psf asumed geotechical engineering to verify for existing foundation

Live Loads: Roof = 30 psfFloor = 40 psfCeilings = 20 psf Attic = 10 psf (no storage) Attic = 20 psf (limited storage) Decks = 40 psf Balconies (Exterior) = 40 psf

Dead Loads: Roof = 15 psfCeilings = 10 psf Floor = 12 psf

Allowable Deflection: Rafters = L/180Ceilings = L/240 Floors = L/360Beams & Headers = L/360 Lintels for Masonry= L/600 (L = Span Length)

Truss Data (Min.): Top Chord: LL= 25 psf DL= 10 psf Bottom Chord: LL= 10 psf (no storage) DL= 5 psf

Seismic Category

Engineered Products LVL's , PSL's, TJI's by Truss Joist Weyerhaeuser

consultants

1261 MEADOW WOODS DF MACEDONIA, OH 44056 PH: 330-467-5877

PRO-E DESIGN, LLC


10556 E. Bayshore E

G

Sid

2 V

8

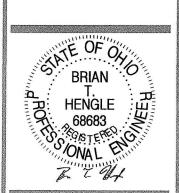

Copyright 2024 Pro-E Design, Inc. All rights reserved. This design and these plans or part thereof must not be re-produced in any form without the written permission of Pro E Designs, Inc.


These plans can only be used for the specific project stated in the title block.


DATE ISSUE

2/7/25

SHEET TITLE

cover sheet

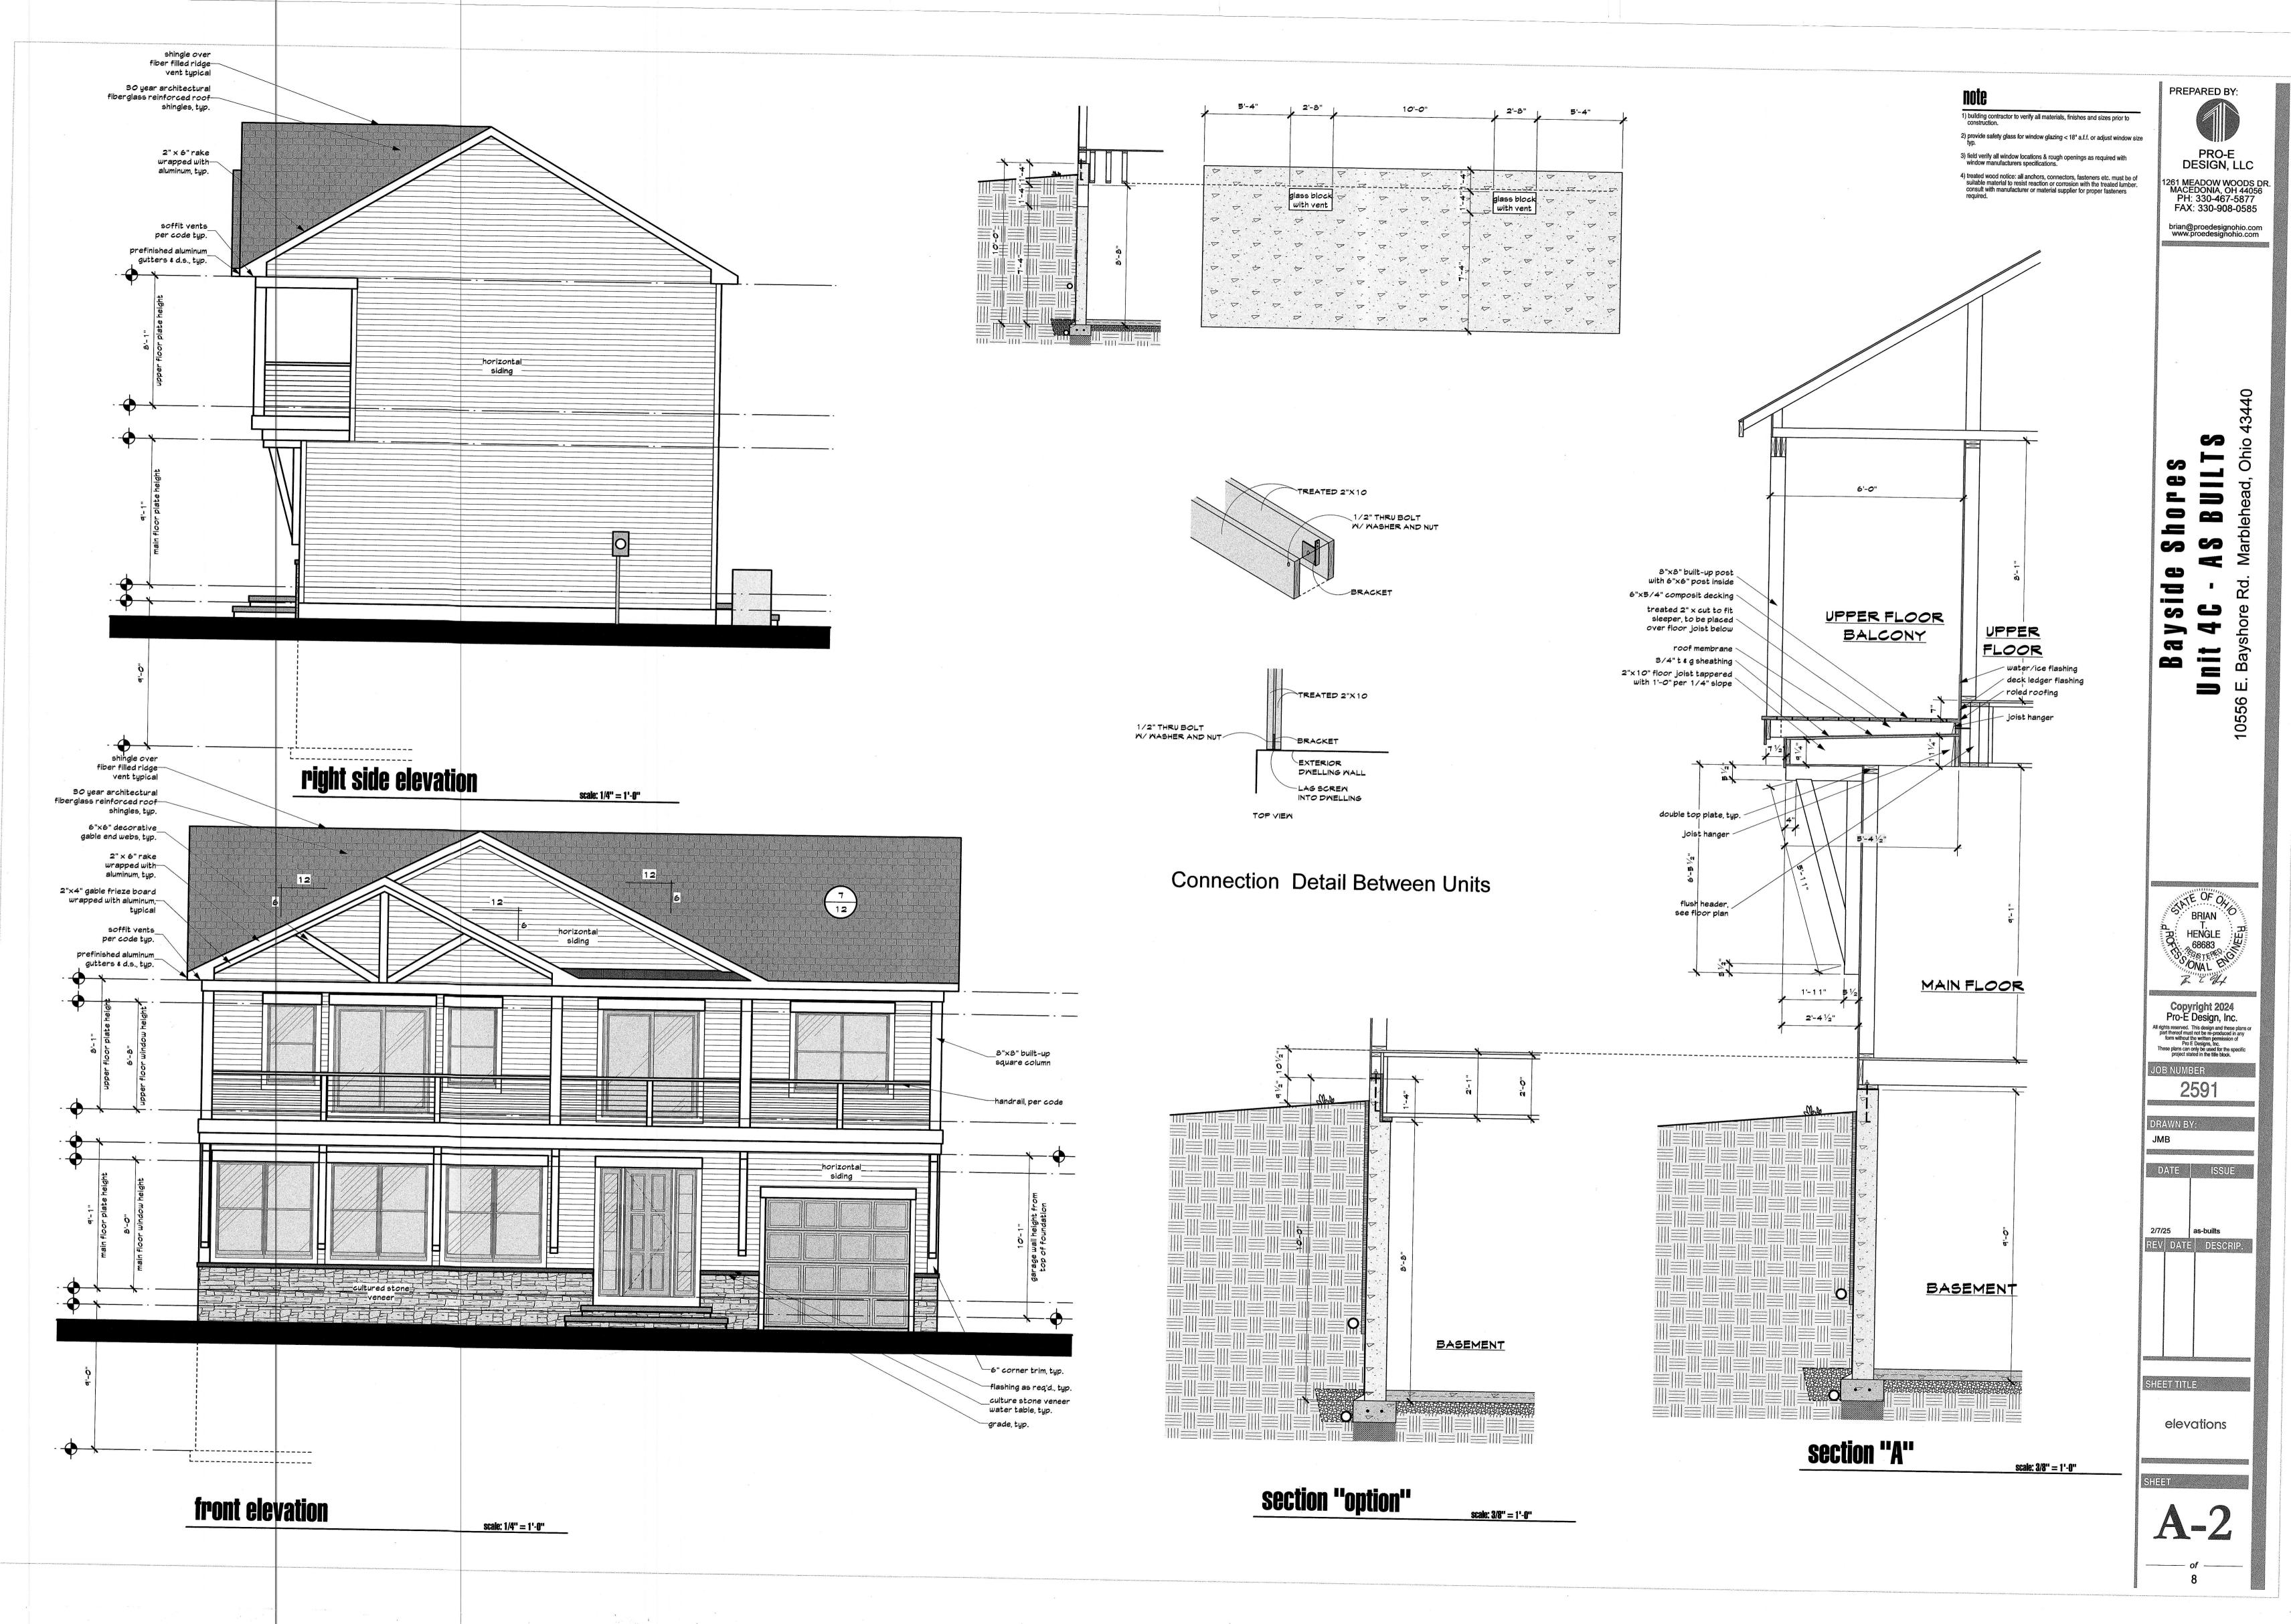

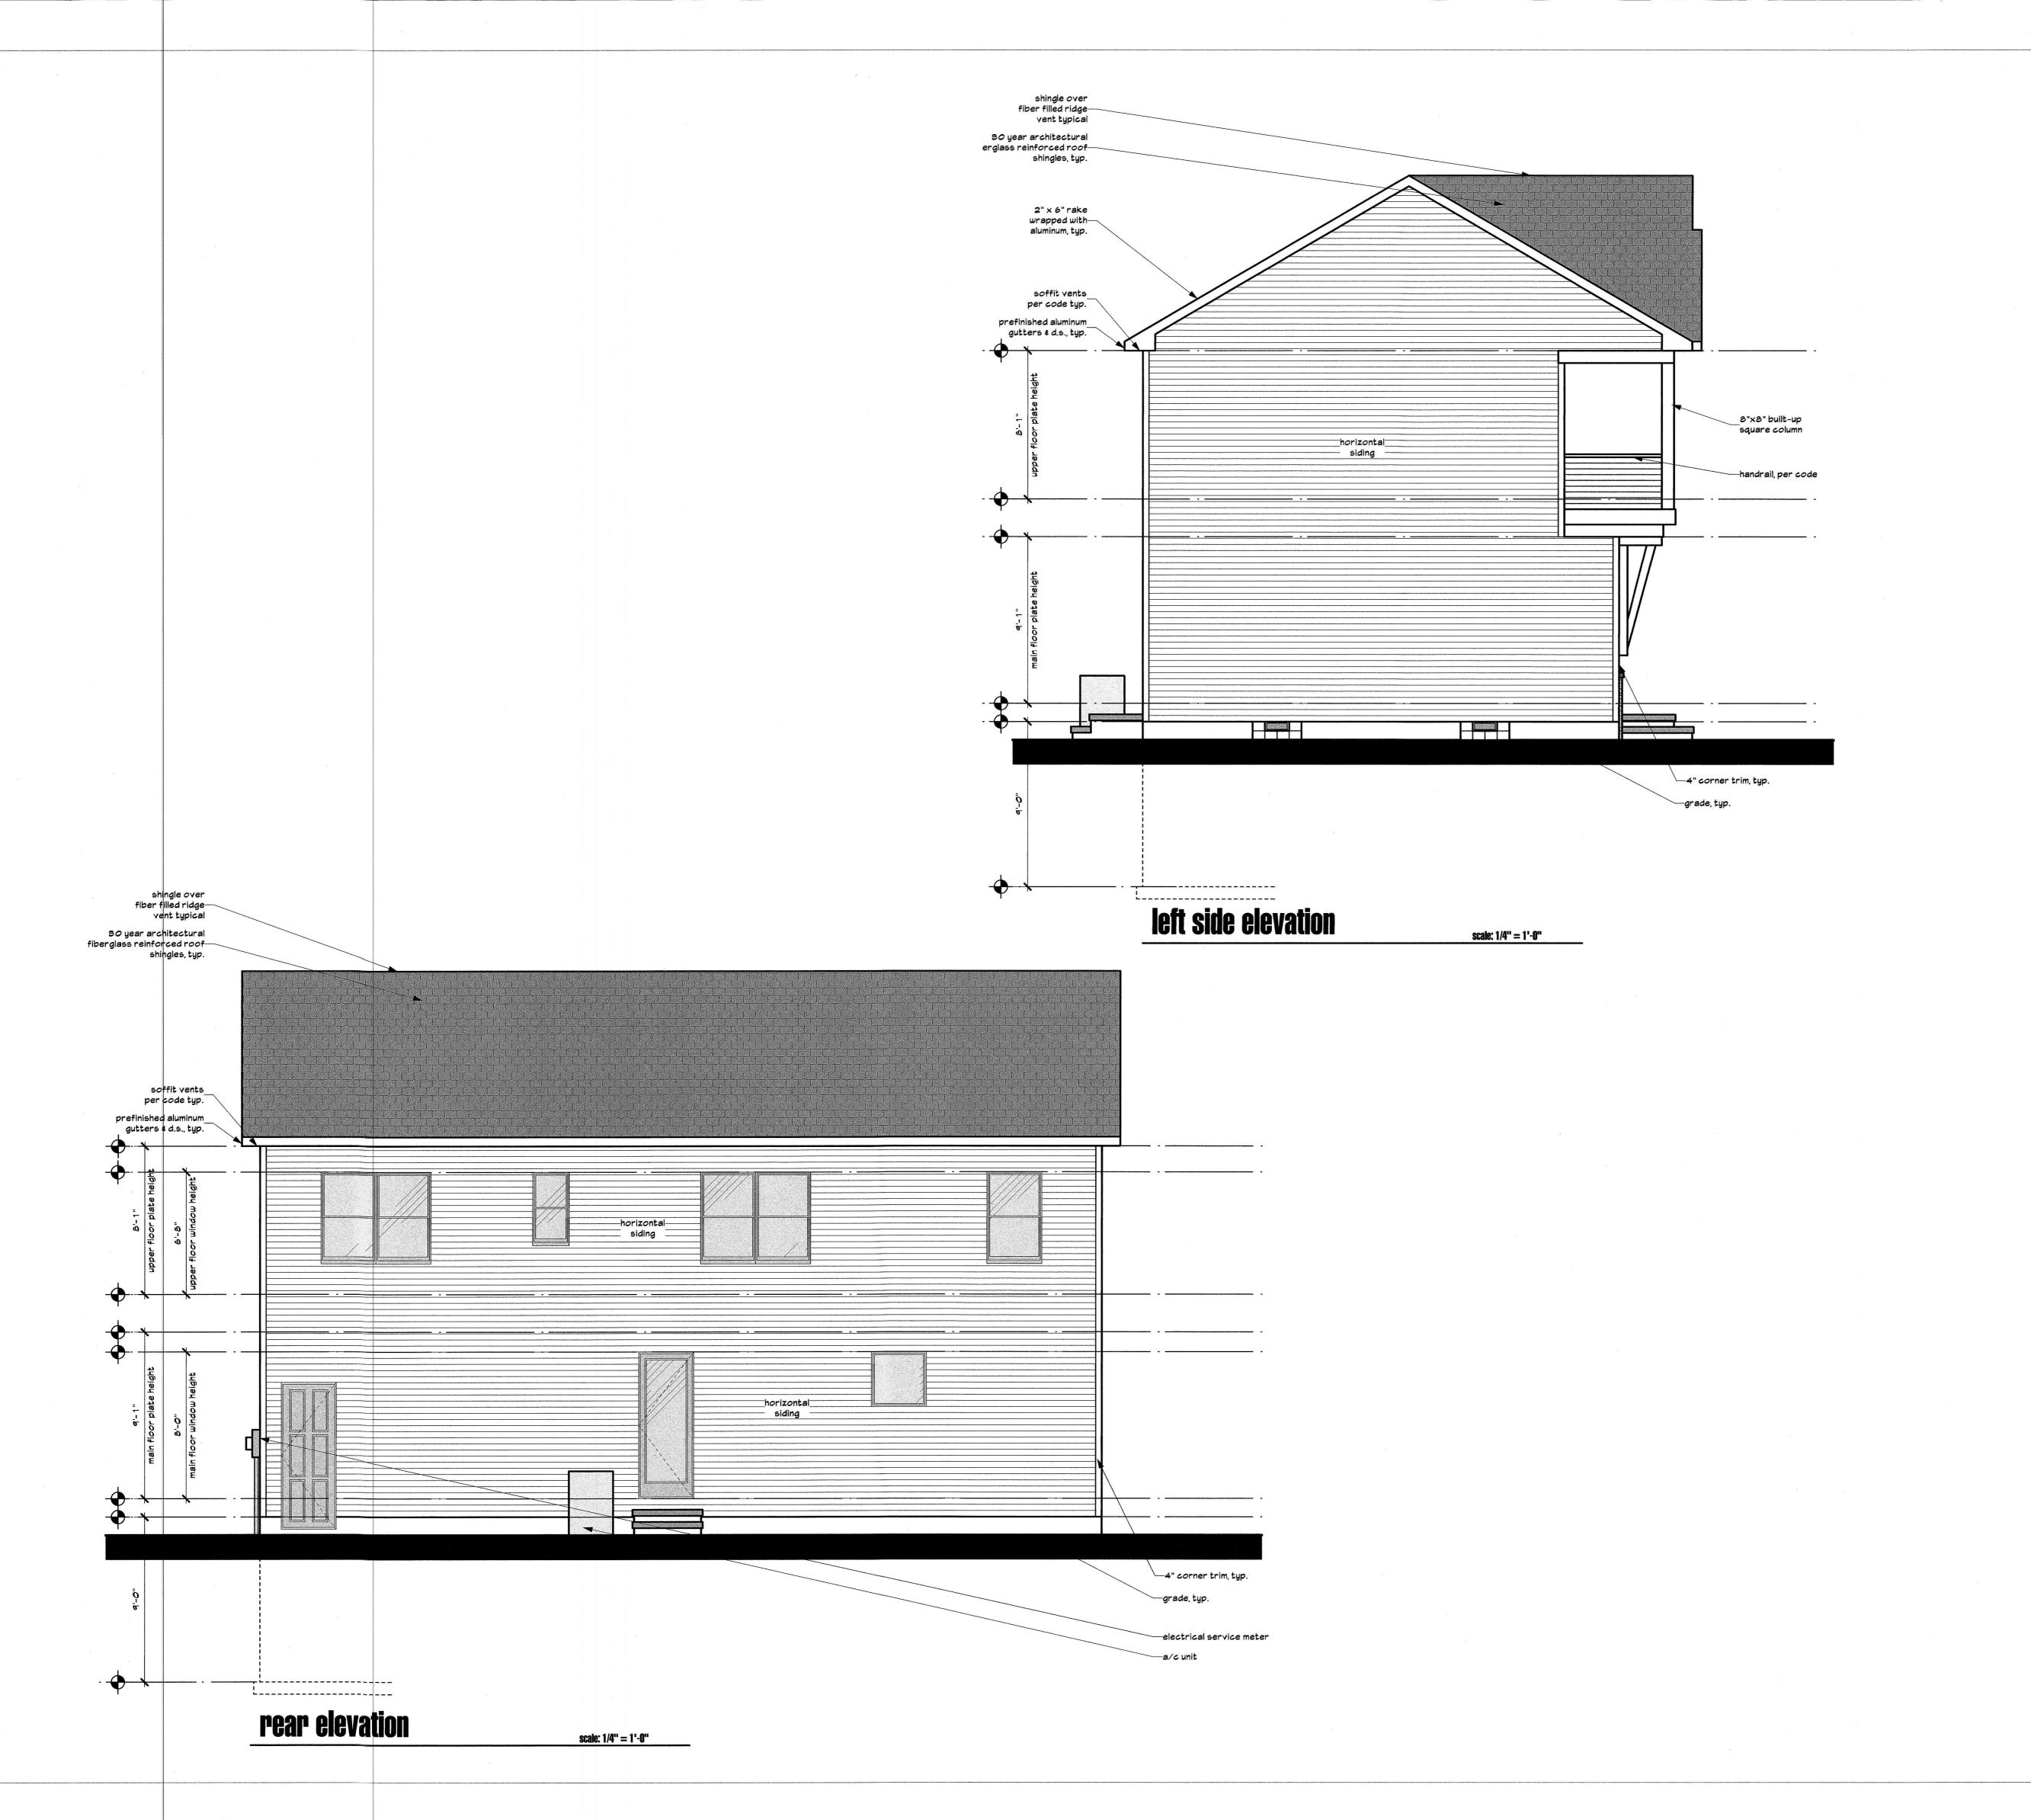

building contractor to verify all materials, finishes and sizes prior to construction.

2) provide safety glass for window glazing < 18" a.f.f. or adjust window size typ.

3) field verify all window locations & rough openings as required with window manufacturers specifications.

4) treated wood notice: all anchors, connectors, fasteners etc. must be of suitable material to resist reaction or corrosion with the treated lumber. consult with manufacturer or material supplier for proper fasteners required.



S

æ

PREPARED BY:

PH: 330-467-5877
FAX: 330-908-0585
brian@proedesignohio.com
www.proedesignohio.com

BRIAN T.
HENGLE
68683

Bayshore

Ξ

Copyright 2024
Pro-E Design, Inc.

All rights reserved. This design and these plans or part thereof must not be re-produced in any form without the written permission of Pro E Designs, Inc.

These plans can only be used for the specific project stated in the title block.

JOB NUMBER

2591

MB
DATE ISSUE

DATE ISSUE

2/7/25 as-builts

REV DATE DESCRIP.

SHEET TITLE

elevations

A_3

__ of ___

header schedule

typical header u.n.o.

(2) 2"x10" with 1/2" plywood spacer for 2"x4' walls.

(3) 2"x10" with 1/2" plywood spacer for 2"x6" walls.

* IvI's denote laminated veneer lumber seltions with section depths indicated on plan.

* all Ivl's are 1 3/4" wide typical.

* all IvI's are flush with floor framing u.n.o.

unless noted otherwise, 4'-0" openings shall have 1 jamb & 1 king stud each side. openings over 4"-0" shall have 2 jamb & 2 king studs each side.

* block all posts & multi stud posts to solid support below. multi stud posts shall be glued & nailed.

* all columns to be latterally braced full length.

(5)2x6

C2 (4)2x4

C3 (5)2x4

with 1/2" bearing plate and cap plate bolted to sound bearing and beam above

4x4 treated wood post with post base and post cap on 16" dia. x 48" deep conc. footing on undisturbed soil

6x6 treated wood post with post base and post cap on 20" dia. x 48" deep conc. footing on undisturbed soil

P3 8x8 treated wood post with post base and post cap on 32" dia. x 48" deep conc. footing on undisturbed soil

steel column & footing schedule

3" ø schedule 40 adjustable steel column standard weight (7.6 plf) over 36"x36"x12" deep conc. footing with (4)#5 bars each way

3" ø schedule 40 adjustable steel column standard weight (7.6 plf) over 30x30"x12" deep conc. footing with (3)#5 bars each way at bottom

4" ø 11ga. adjustable steel column over 24"x24"x12" deep footing with (3) #5 bars each way

30x30"x12" deep conc. footing with (4)#5 bars each way at bottom

3" ø schedule 40 adjustable steel column standard weight (7.6 plf) over 36x36"x12" deep conc. footing with (3)#5 bars each way at bottom

3" ø (3 1/2" o.d.) schedule 40 fixed steel column over 60x60"x12" deep conc. footing with (5)#5 bars each way at bottom


treated wood note

 all anchors, connectors, fasteners etc. must be of suitable material to resist reaction or corrosion with the treated lumber. consult with manufacturer or material supplier for proper fasteners required.

2) provide preservative treated wood with quality mark at:


a.) framing members with in 8" of grade on concrete or masonry.


b.) exterior wood siding/sheathing/wall framing with in 6" of grade or 2" of concrete steps, porch slab, orpatio slab or similar.

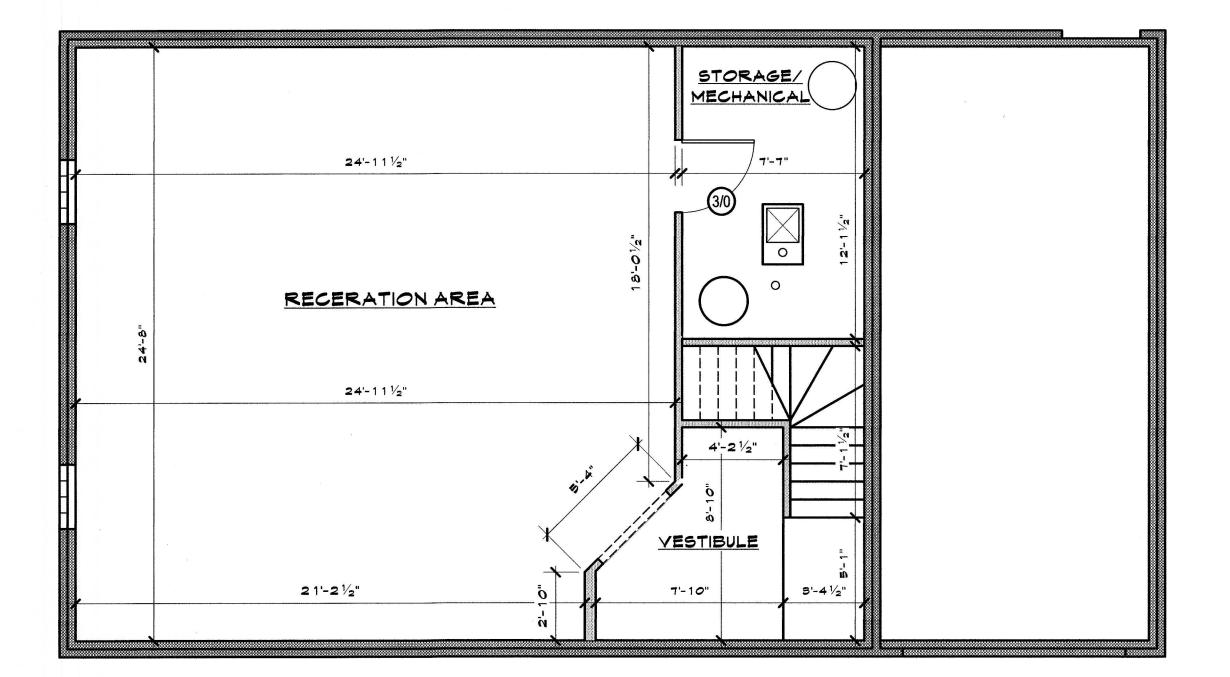

basement floor plan

scale: 1/4" = 1'-0"

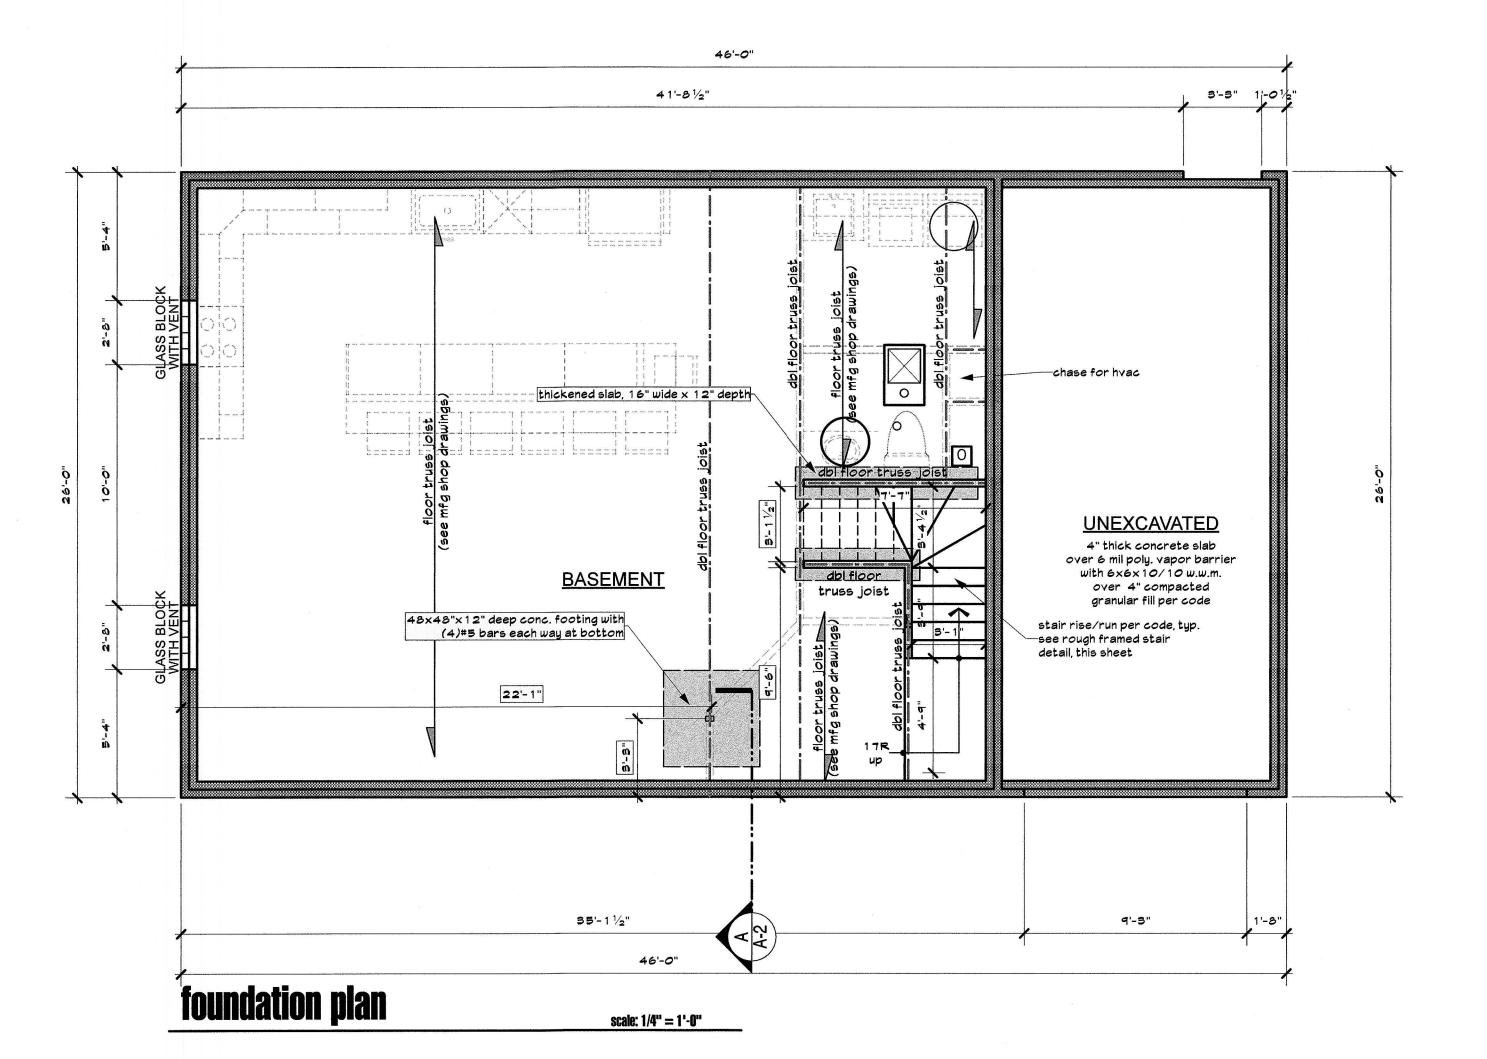

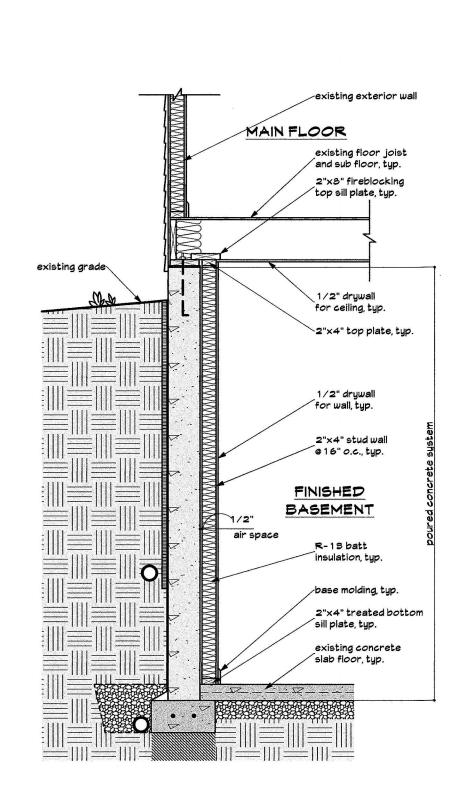

typical finihsheed basement wall section

foundation notes (poured walls)

1) 9' h. x 8" w. reinforced solid concrete wall
- provide (1) #6 vertical steel reinforcing bar (full height)
@ 32" o.c. with 6" into footing
- provide min. of (3) #4 rebar horizonally with
(1) #4 rebar 12" from top,
(1) #4 rebar 21" from bottom

(1) #4 rebar 12" from bottom, (bars 2" min. from inside wall face - wire tie all bars) 2) typical footing
- 8" h. x 16" w. reinf. concrete w/ (2) #4 rebars continus. verify soil class and conditions, adjust as required

PREPARED BY:

DESIGN, LLC

1261 MEADOW WOODS DR. MACEDONIA, OH 44056

PH: 330-467-5877 FAX: 330-908-0585

brian@proedesignohio.com www.proedesignohio.com

GD

63

7

-

5

Œ

STATE OF OUT

BRIAN

HENGLE 68683

ONAL E

Copyright 2024 Pro-E Design, Inc.

RAWN BY:

EV DATE DESCRIP.

2/7/25

3) provide min. 5" for beam bearing & (2) #6 vert. steel reinf. bars (full ht.) @ all beam bearing locations 4) all dimenstions are to be taken from the face concrete foundation wall or rough framing 5) see topo for all grades and spot elevations

6) step footings as req'd to maintain 3'-6" min. frost depth 7) double joists under parallel walls above provide solid blocking between joists to found, wall or beam under all point loads from above

floor joist schedule

Ohio Residential Building Code 2019 RS502.21(2) Lumber Spruce-Pine-Fir (SPF) #2 or equal., unless noted otherwise. Refer to TJI floor joist shop drawings for layout and spaceing of joist.

provide simpson 'hw' or equal beam hangers @ all upset wood beam hanger conditions

20" TJI floor joists @ 12" o.c. with bracing per mfg. shop drawings. (series 560)

20" TJI floor joists @ 16" o.c. with bracing per mfg. shop drawings. (series 560)

20" TJI floor joists @ 12" o.c. with bracing per mfg. shop drawings. (series 360)

20" TJI floor joists @ 16" o.c. with bracing per mfg. shop drawings. (series 360)

20" TJI floor joists @ 12" o.c. with bracing per of mfg. shop drawings. (series 210)

20" TJI floor joists @ 16" o.c. with bracing per mfg. shop drawings. (series 210)

16" TJI floor joists @ 12" o.c. with bracing per mfg. shop drawings. (series 560)

16" TJI floor joists @ 16" o.c. with bracing per mfg. shop drawings. (series 560) 16" TJI floor joists @ 12" o.c. with bracing per mfg. shop drawings. (series 360)

16" TJI floor joists @ 16" o.c. with bracing per mfg. shop drawings. (series 360)

16" TJI floor joists @ 12" o.c. with bracing per mfg. shop drawings. (series 210)

16" TJI floor joists @ 16" o.c. with bracing per mfg. shop drawings. (series 210) 14" TJI floor joists @ 12" o.c. with bracing per mfg. shop drawings. (series 560)

14" TJI floor joists @ 16" o.c. with bracing per mfg. shop drawings. (series 560)

14" TJI floor joists @ 12" o.c. with bracing per mfg. shop drawings. (series 360)

14" TJI floor joists @ 16" o.c. with bracing per mfg. shop drawings. (series 360)

14" TJI floor joists @ 12" o.c. with bracing per mfg. shop drawings. (series 210) 14" TJI floor joists @ 16" o.c. with bracing per mfg. shop drawings. (series 210)

11 7/8" TJI floor joists @ 12" o.c. with bracing per mfg. shop drawings. (series 560)

11 7/8" TJI floor joists @ 16" o.c. with bracing per mfg. shop drawings. (series 560)

11 7/8" TJI floor joists @ 12" o.c. with bracing per mfg. shop drawings. (series 360)

11 7/8" TJI floor joists @ 16" o.c. with bracing per mfg. shop drawings. (series 360)

11 7/8" TJI floor joists @ 12" o.c. with bracing per mfg. shop drawings. (series 210)

11 7/8" TJI floor joists @ 16" o.c. with bracing per mfg. shop drawings. (series 210) 9 1/2" TJI floor joists @ 12" o.c. with bracing per mfg. shop drawings. (series 560)

9 1/2" TJI floor joists @ 16" o.c. with bracing per mfg. shop drawings. (series 560)

9 1/2" TJI floor joists @ 12" o.c. with bracing per mfg. shop drawings. (series 360)

9 1/2" TJI floor joists @ 16" o.c. with bracing per mfg. shop drawings. (series 360)

9 1/2" TJI floor joists @ 12" o.c. with bracing per mfg. shop drawings. (series 210) 9 1/2" TJI floor joists @ 16" o.c. with bracing per mfg. shop drawings. (series 210)

2X12 floor joists @ 16" o.c. with 'x' bracing @ midspan or as required.

M 2X12 floor joists @ 16" o.c. double every other oist with 'x' bracing @ midspan or as required.

N (2) 2X12 floor joists @ 16" o.c. with 'x' bracing @ midspan or as required. 2X10 floor joists @ 16" o.c. with 'x' bracing @ midspan or as required.

2X10 floor joists @ 16" o.c. double every other joist with 'x' bracing @ midspan or as required.


(2) 2X10 floor joists @ 16" o.c. with 'x' bracing @ midspan or as required. 2X8 treated floor joists @ 16" o.c. with 'x' bracing @ midspan or as required.

F1 pre-engineered floor truss system refer to mfg. shop drawings

HEET TITLE

foundation

basement floor plan

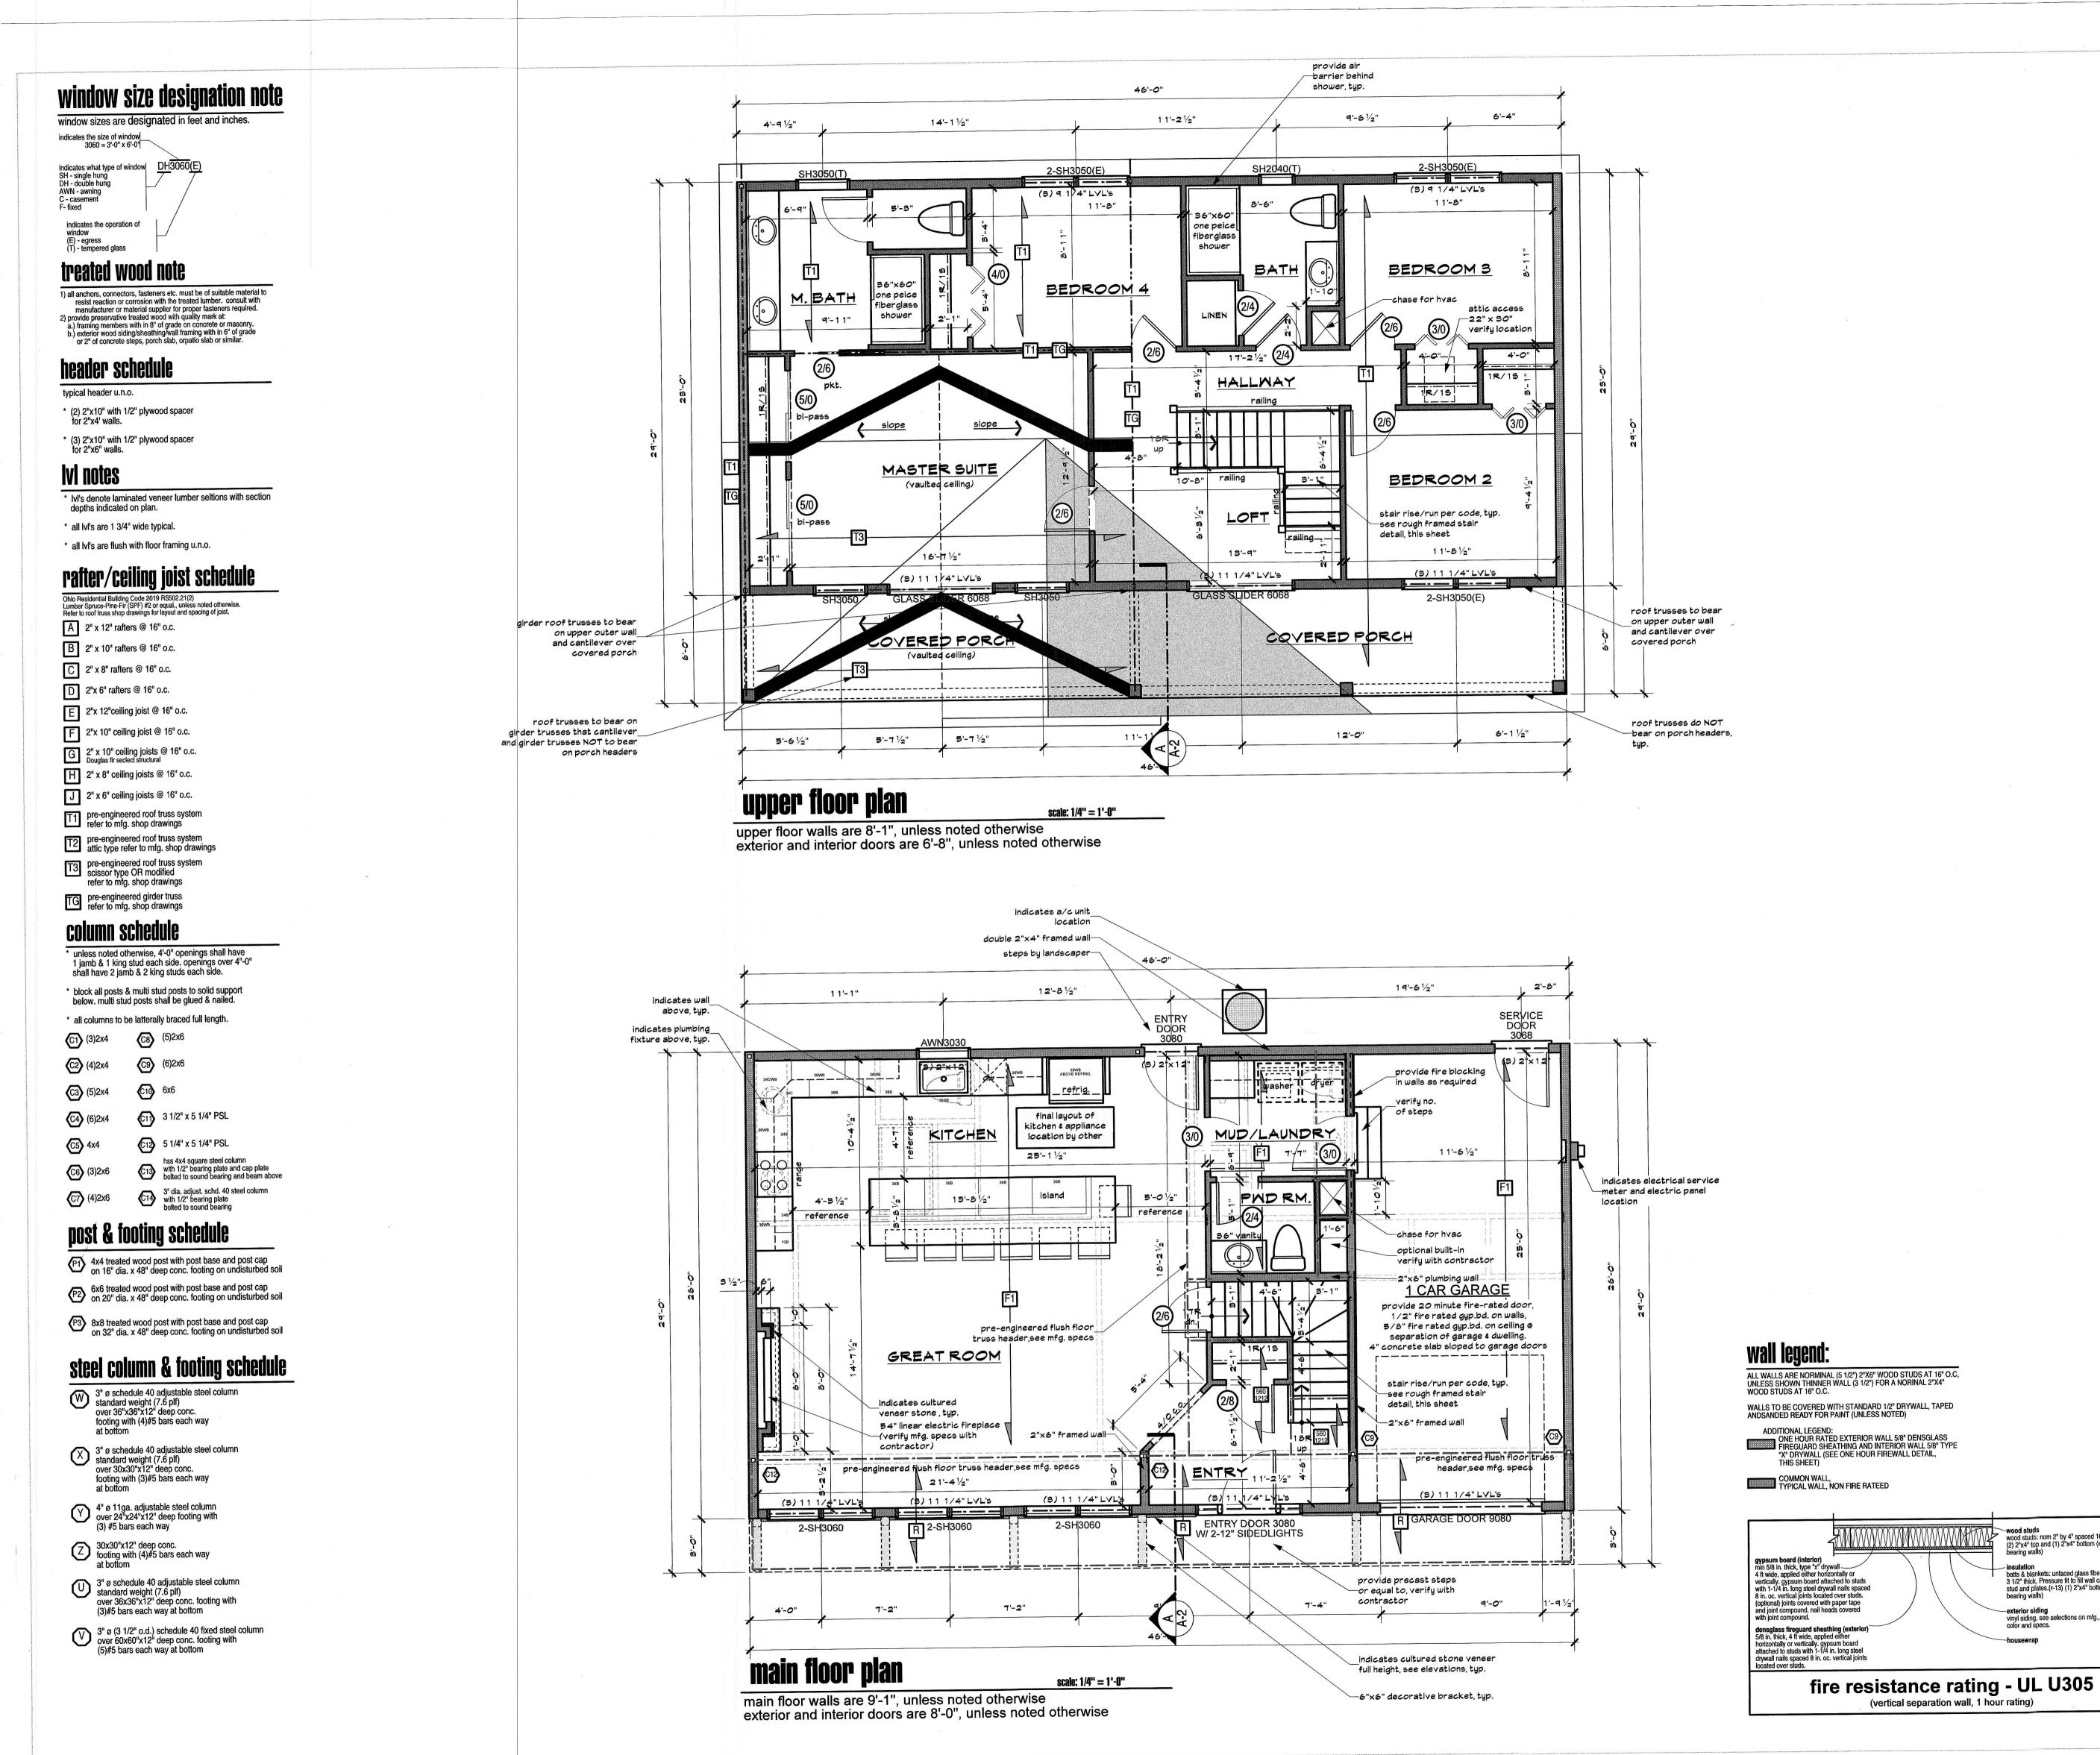

general plan notes

(1/2" sheathing with 3 1/2" rough, unless otherwise noted) or exterior walls are dimensioned at 6" to the outside (1/2" sheathing with 5 1/2" rough, unless otherwise noted) interior wood framed walls are dimensioned at 3 1/2" rough, unless

2) building contractor must verify all site conditions prior to commencement

3) all wall angles are 45 degrees unless otherwise noted.

4) field verify all window locations & rough openings as required with window manufacturers specifications.

5) provide safety glass for window glazing < 18" a.f.f. or adjust window size

6) structural and framing members indicated are sized based on species of lumber that satisfy the span. 7) builder to verify that all roof truss bracing and bear on load bearing walls which align as shown and terminate at foundation and be supported by thickened slab grade beam or footing as indicated.

wall bracing notes

all exterior walls shall be continuously sheathed and built per wall type 1 specification indicated on wall brace details, sheet A-9

denotes type 2 interior braced wall to be built per specifications and details on sheet A-9

floor joist schedul

Ohio Residential Building Code 2019 RS502.21(2) Lumber Spruce-Pine-Fir (SPF) #2 or equal., unless noted otherwise. Refer to TJI floor joist shop drawings for layout and spaceing of joist.

20" TJI floor joists @ 12" o.c. with bracing per mfg. shop drawings. (series 560)

20" TJI floor joists @ 16" o.c. with bracing per mfg. shop drawings. (series 560)

20" TJI floor joists @ 12" o.c. with bracing per mfg. shop drawings. (series 360)

20" TJI floor joists @ 16" o.c. with bracing per mfg. shop drawings. (series 360)

20" TJI floor joists @ 12" o.c. with bracing per mfg. shop drawings. (series 210) 20" TJI floor joists @ 16" o.c. with bracing per mfg. shop drawings. (series 210)

16" TJI floor joists @ 12" o.c. with bracing per mfg. shop drawings. (series 560)

16" TJI floor joists @ 16" o.c. with bracing per mfg. shop drawings. (series 560)

16" TJI floor joists @ 12" o.c. with bracing per mfg. shop drawings. (series 360) 16" TJI floor joists @ 16" o.c. with bracing per mfg. shop drawings. (series 360)

16" TJI floor joists @ 12" o.c. with bracing per mfg. shop drawings. (series 210)

16" TJI floor joists @ 16" o.c. with bracing per mfg. shop drawings. (series 210)

14" TJI floor joists @ 12" o.c. with bracing per mfg. shop drawings. (series 560) 14" TJI floor joists @ 16" o.c. with bracing per mfg. shop drawings. (series 560)

14" TJI floor joists @ 12" o.c. with bracing per mfg. shop drawings. (series 360)

14" TJI floor joists @ 16" o.c. with bracing per mfg. shop drawings. (series 360)

14" TJI floor joists @ 12" o.c. with bracing per mfg. shop drawings. (series 210)

14" TJI floor joists @ 16" o.c. with bracing per mfg. shop drawings. (series 210)

11 7/8" TJI floor joists @ 12" o.c. with bracing per mfg. shop drawings. (series 560)

11 7/8" TJI floor joists @ 16" o.c. with bracing per mfg. shop drawings. (series 560)

11 7/8" TJI floor joists @ 12" o.c. with bracing per mfg. shop drawings. (series 360)

11 7/8" TJI floor joists @ 16" o.c. with bracing per mfg. shop drawings. (series 360)

11 7/8" TJI floor joists @ 12" o.c. with bracing per mfg. shop drawings. (series 210)

11 7/8" TJI floor joists @ 16" o.c. with bracing per mfg. shop drawings. (series 210)

9 1/2" TJI floor joists @ 12" o.c. with bracing per mfg. shop drawings. (series 560)

9 1/2" TJI floor joists @ 16" o.c. with bracing per mfg. shop drawings. (series 560)

9 1/2" TJI floor joists @ 12" o.c. with bracing per mfg. shop drawings. (series 360) 9 1/2" TJI floor joists @ 16" o.c. with bracing per mfg. shop drawings. (series 360)

9 1/2" TJI floor joists @ 12" o.c. with bracing per mfg. shop drawings. (series 210) 9 1/2" TJI floor joists @ 16" o.c. with bracing per mfg. shop drawings. (series 210)

2X12 floor joists @ 16" o.c. with 'x' bracing @ midspan or as required.

M 2X12 floor joists @ 16" o.c. double every other oist with 'x' bracing @ midspan or as required.

(2) 2X12 floor joists @ 16" o.c. with 'x' bracing @ midspan or as required.

wood studs wood studs: nom 2" by 4" spaced 16" o/c w/ (2) 2"x4" top and (1) 2"x4" bottom (exterior bearing walls)

batts & blankets: unfaced glass fiber insulation, 3 1/2" thick, Pressure fit to fill wall cavaties between stud and plates.(r-13) (1) 2"x4" bottom (exterior

vinyl siding, see selections on mfg.,

(vertical separation wall, 1 hour rating)

2X10 floor joists @ 16" o.c. with 'x' bracing @ midspan or as required. P 2X10 floor joists @ 16" o.c. double every other joist with 'x' bracing @ midspan or as required.

(2) 2X10 floor joists @ 16" o.c. with 'x' bracing @ midspan or as required.

R 2X8 treated floor joists @ 16" o.c. with 'x' bracing @ midspan or as required.

F1 pre-engineered floor truss system refer to mfg. shop drawings

brian@proedesignohio.com www.proedesignohio.com

PREPARED BY:

PRO-E

DESIGN, LLC

1261 MEADOW WOODS DR. MACEDONIA, OH 44056 PH: 330-467-5877

FAX: 330-908-0585

8 6 5

STATE OF ON BRIAN HENGLE 68bou ONA L B. T DH

Copyright 2024 Pro-E Design, Inc. rights reserved. This design and these plans or part thereof must not be re-produced in any form without the written permission of Pro E Designs, Inc. These plans can only be used for the specific project stated in the title block.

2591 AWN BY:

2/7/25 V DATE DESCRIP.

HEST TITLE

main and upper floor plan